


D-334

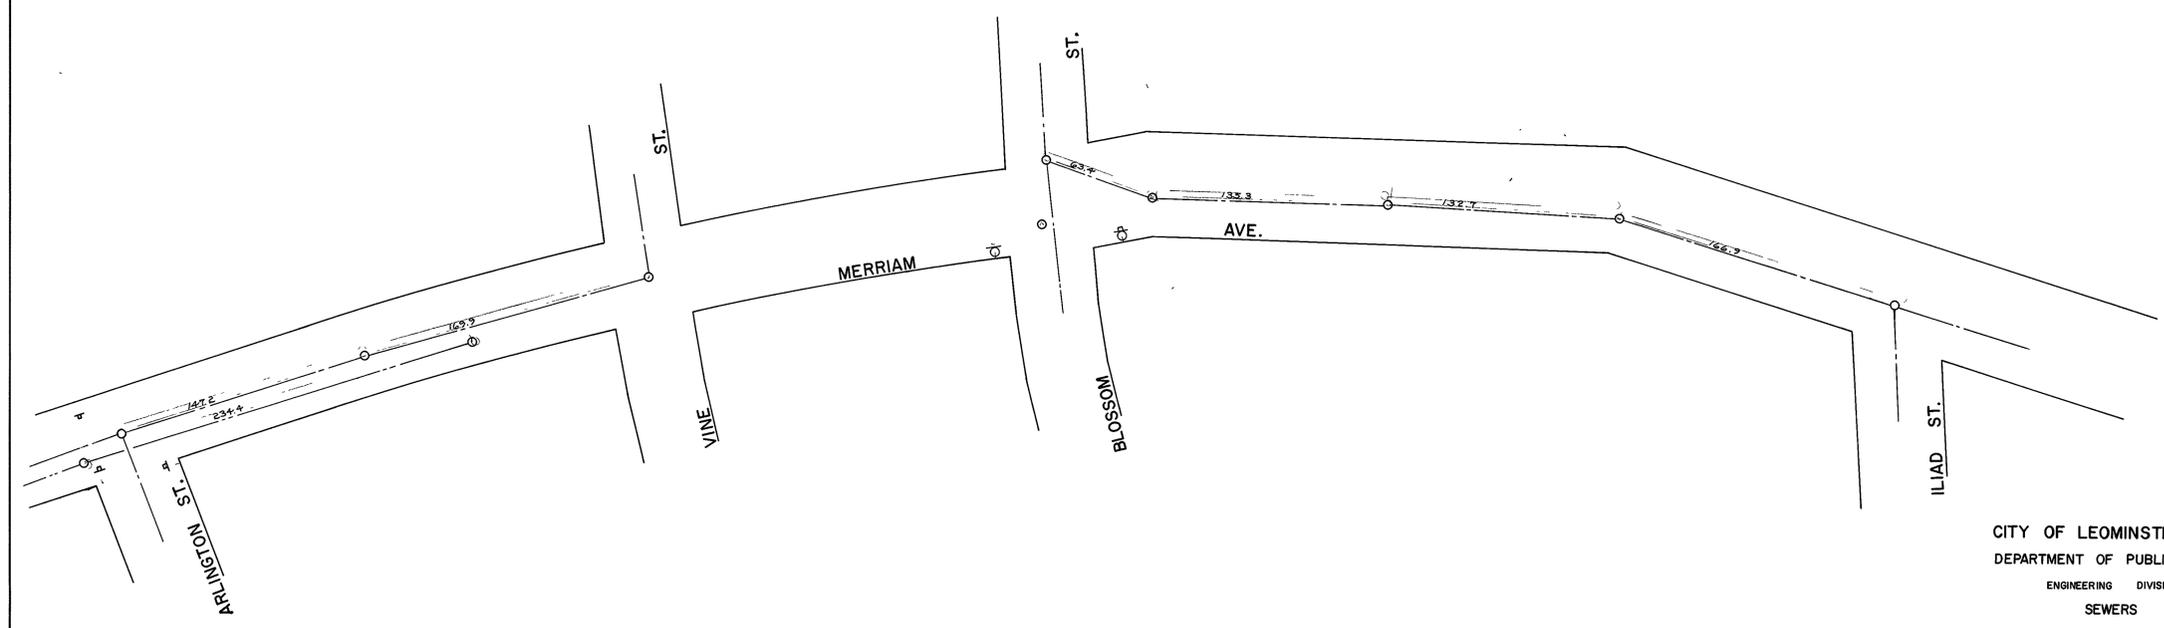

CITY OF LEOMINSTER, MASS.  
DEPARTMENT OF PUBLIC WORKS  
ENGINEERING DIVISION  
SEWERS

**MERRIAM AVE.**  
PLAN AND PROFILE

SCALES: HORIZ. 1"=40' VERT. 1"=8'

FEB. 18, 1977

D-334